

HEATER

550,000 BTU/HR INDIRECT LINE HEATER
42"OD X 10'-0"LG

COIL #1
2"- XXH
DESIGN PRESSURE: 5625 PSIG
DESIGN TEMP.: 200°F
C.A.: 1/8"
RADIOGRAPHY: 100%
PWHT


COIL #2
3"-SCH.80
DESIGN PRESSURE: 1350 PSIG
DESIGN TEMP.: 200°F
C.A.: 1/8"
RADIOGRAPHY: 100%
PWHT

P-1100

METHANOL PUMP
TEXSTEAM 5113

P-1101

GLYCOL PUMP
TEXSTEAM 9000

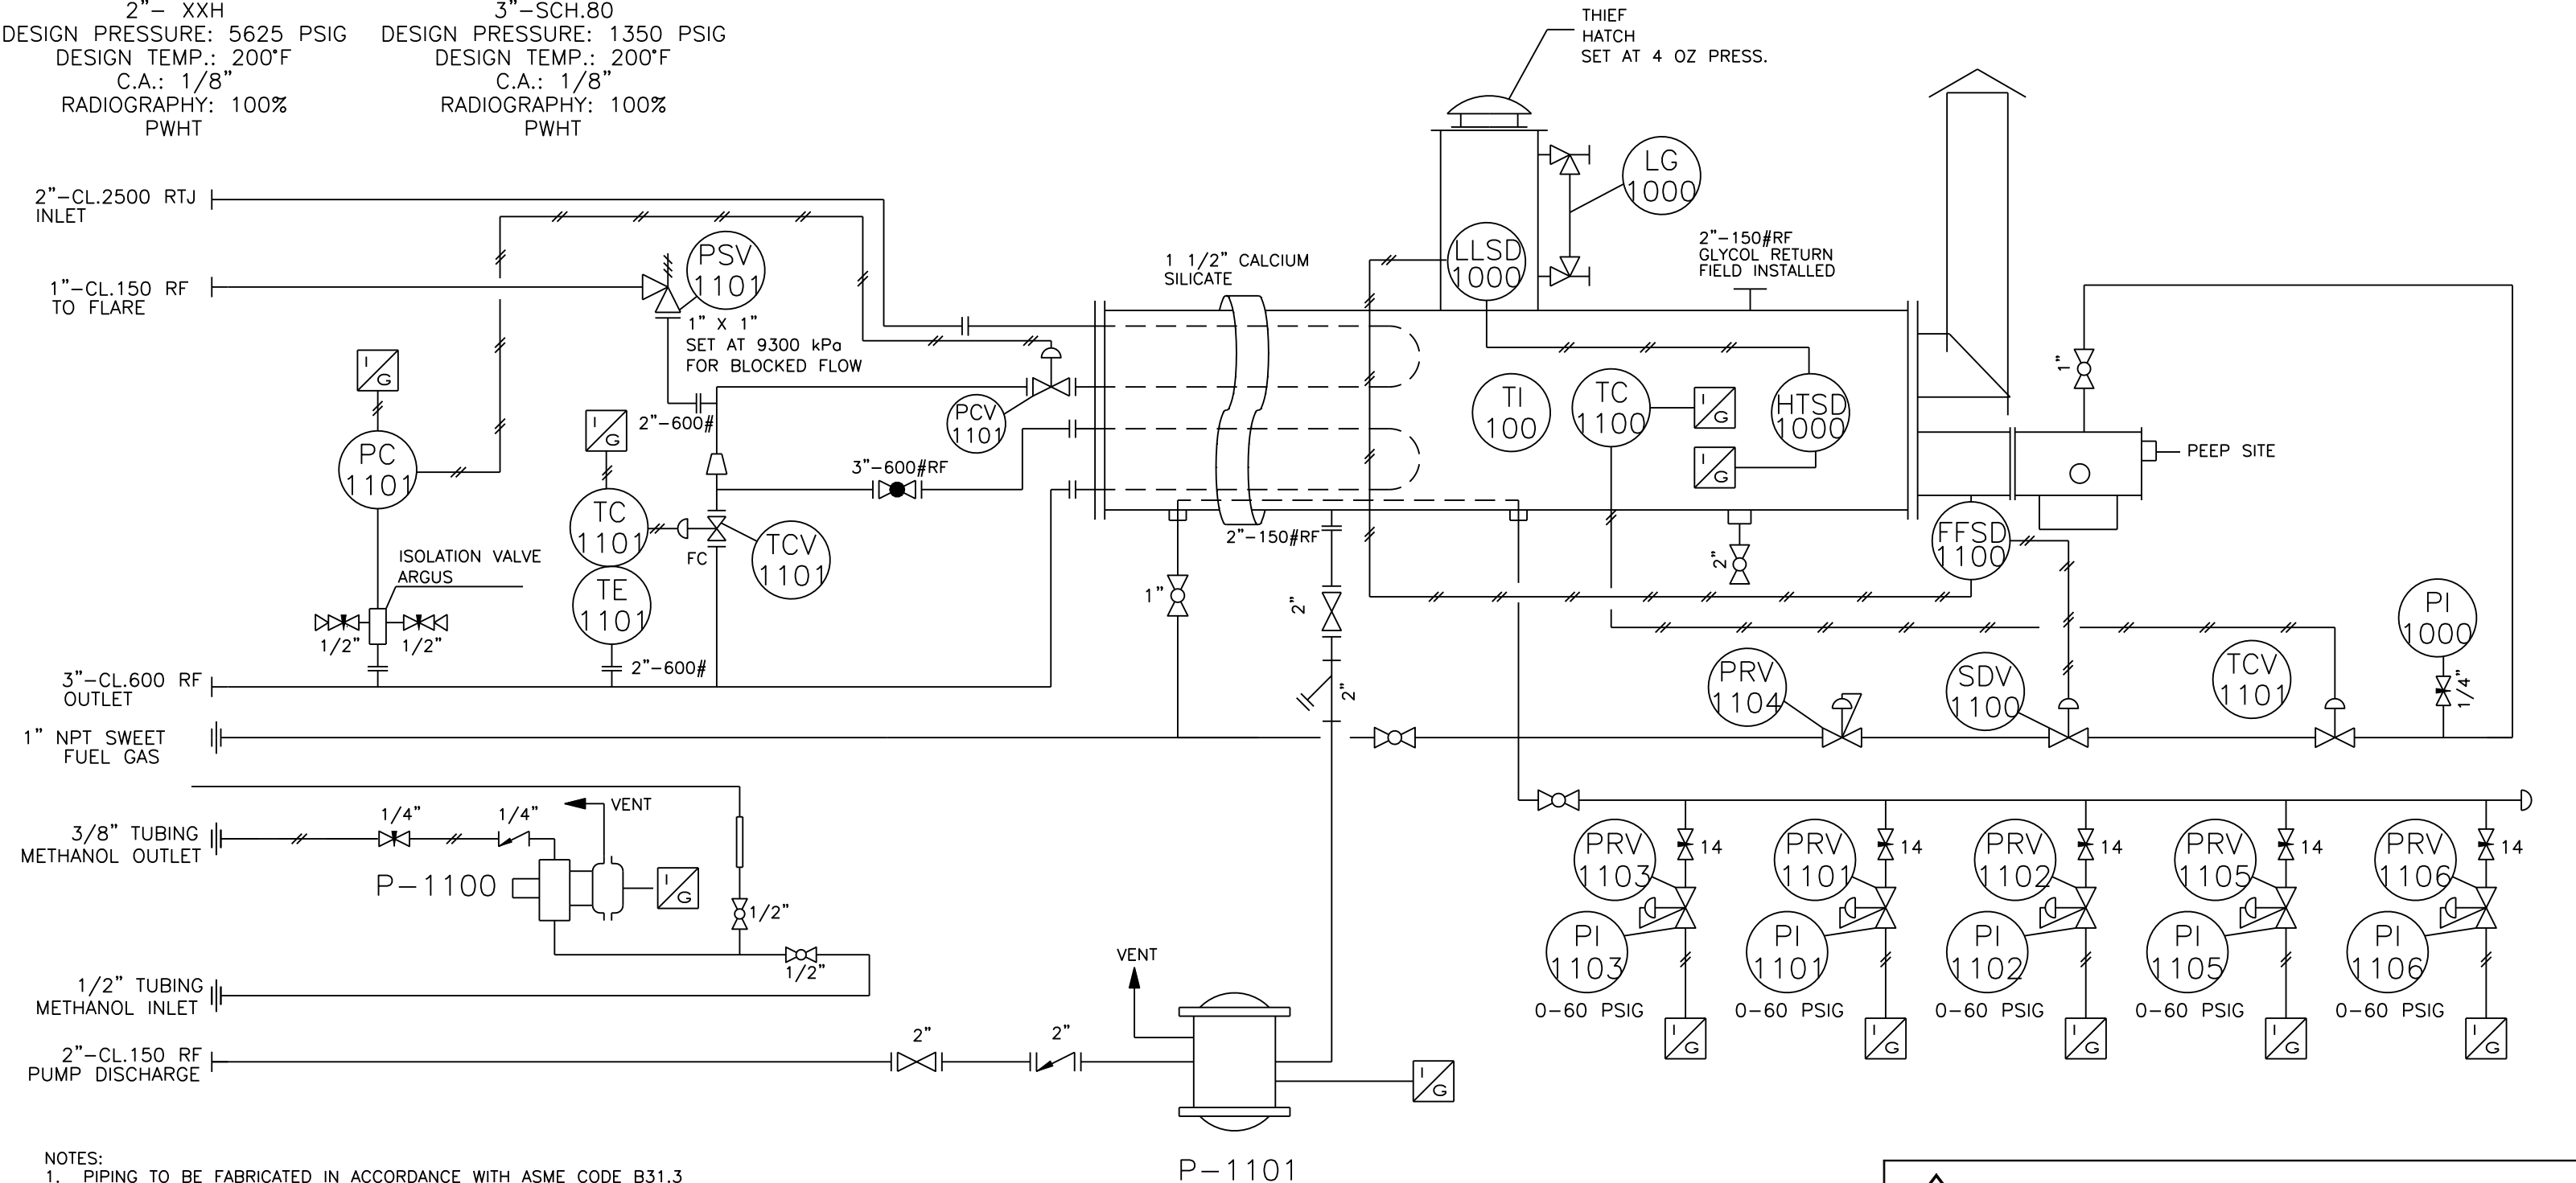

- NOTES:
1. PIPING TO BE FABRICATED IN ACCORDANCE WITH ASME CODE B31.3
 2. 1" PIPING TO BE A-106-B, SCH. 80, FITTINGS - 2000# NPT, A-105.
 3. TUBING TO BE 3/8" & 1/2" 316SS TUBING, C/W SS SWAGelok FITTINGS.
 4. VALVES:
NPT BALL VALVES - NUTRON,
NPT NEEDLE VALVES - AGCO OR EQUAL
GLOBE VALVE - CRANE OR EQUAL.
 5. PAINTING:
SANDBLAST TO SSPC-SP6
ONE (1) COAT OF PRIMER.
ONE COAT OF CLOVATHANE WARM GREY.
STACK SANDBLASTED AND PAINTED HIGH HEAT BLACK.
 6. HEATER VOLUME - 500 IMP. GALLONS.
 7. ESTIMATED TOTAL WEIGHT - 7500 LBS.

NO.	DATE	REVISIONS	DRAWN	CHECK	DESIGN	APPR.
2	08 06 22	AS BUILT	DL			
1	06 06 02	REVISED AS PER CUSTOMER REQUEST	VI			DL
0	06 05 14	FOR APPROVAL	VI			DL



PRIORITY PROJECTS LTD.
BOX 638, 1603-8 STREET, NISKU, ALBERTA T0C-2G0
TELEPHONE: (780) 955-3320 FAX: (780) 955-2561

550,000 BTU/HR INDIRECT LINE HEATER
42" O.D. x 10'-0" LG
PIPING AND INSTRUMENTATION DIAGRAM

CUSTOMER NAME DEVON CANADA CORPORATION	SCALE NTS	DRAWING NUMBER 6144-100	REV. 2
CUSTOMER DWG NUMBER			