


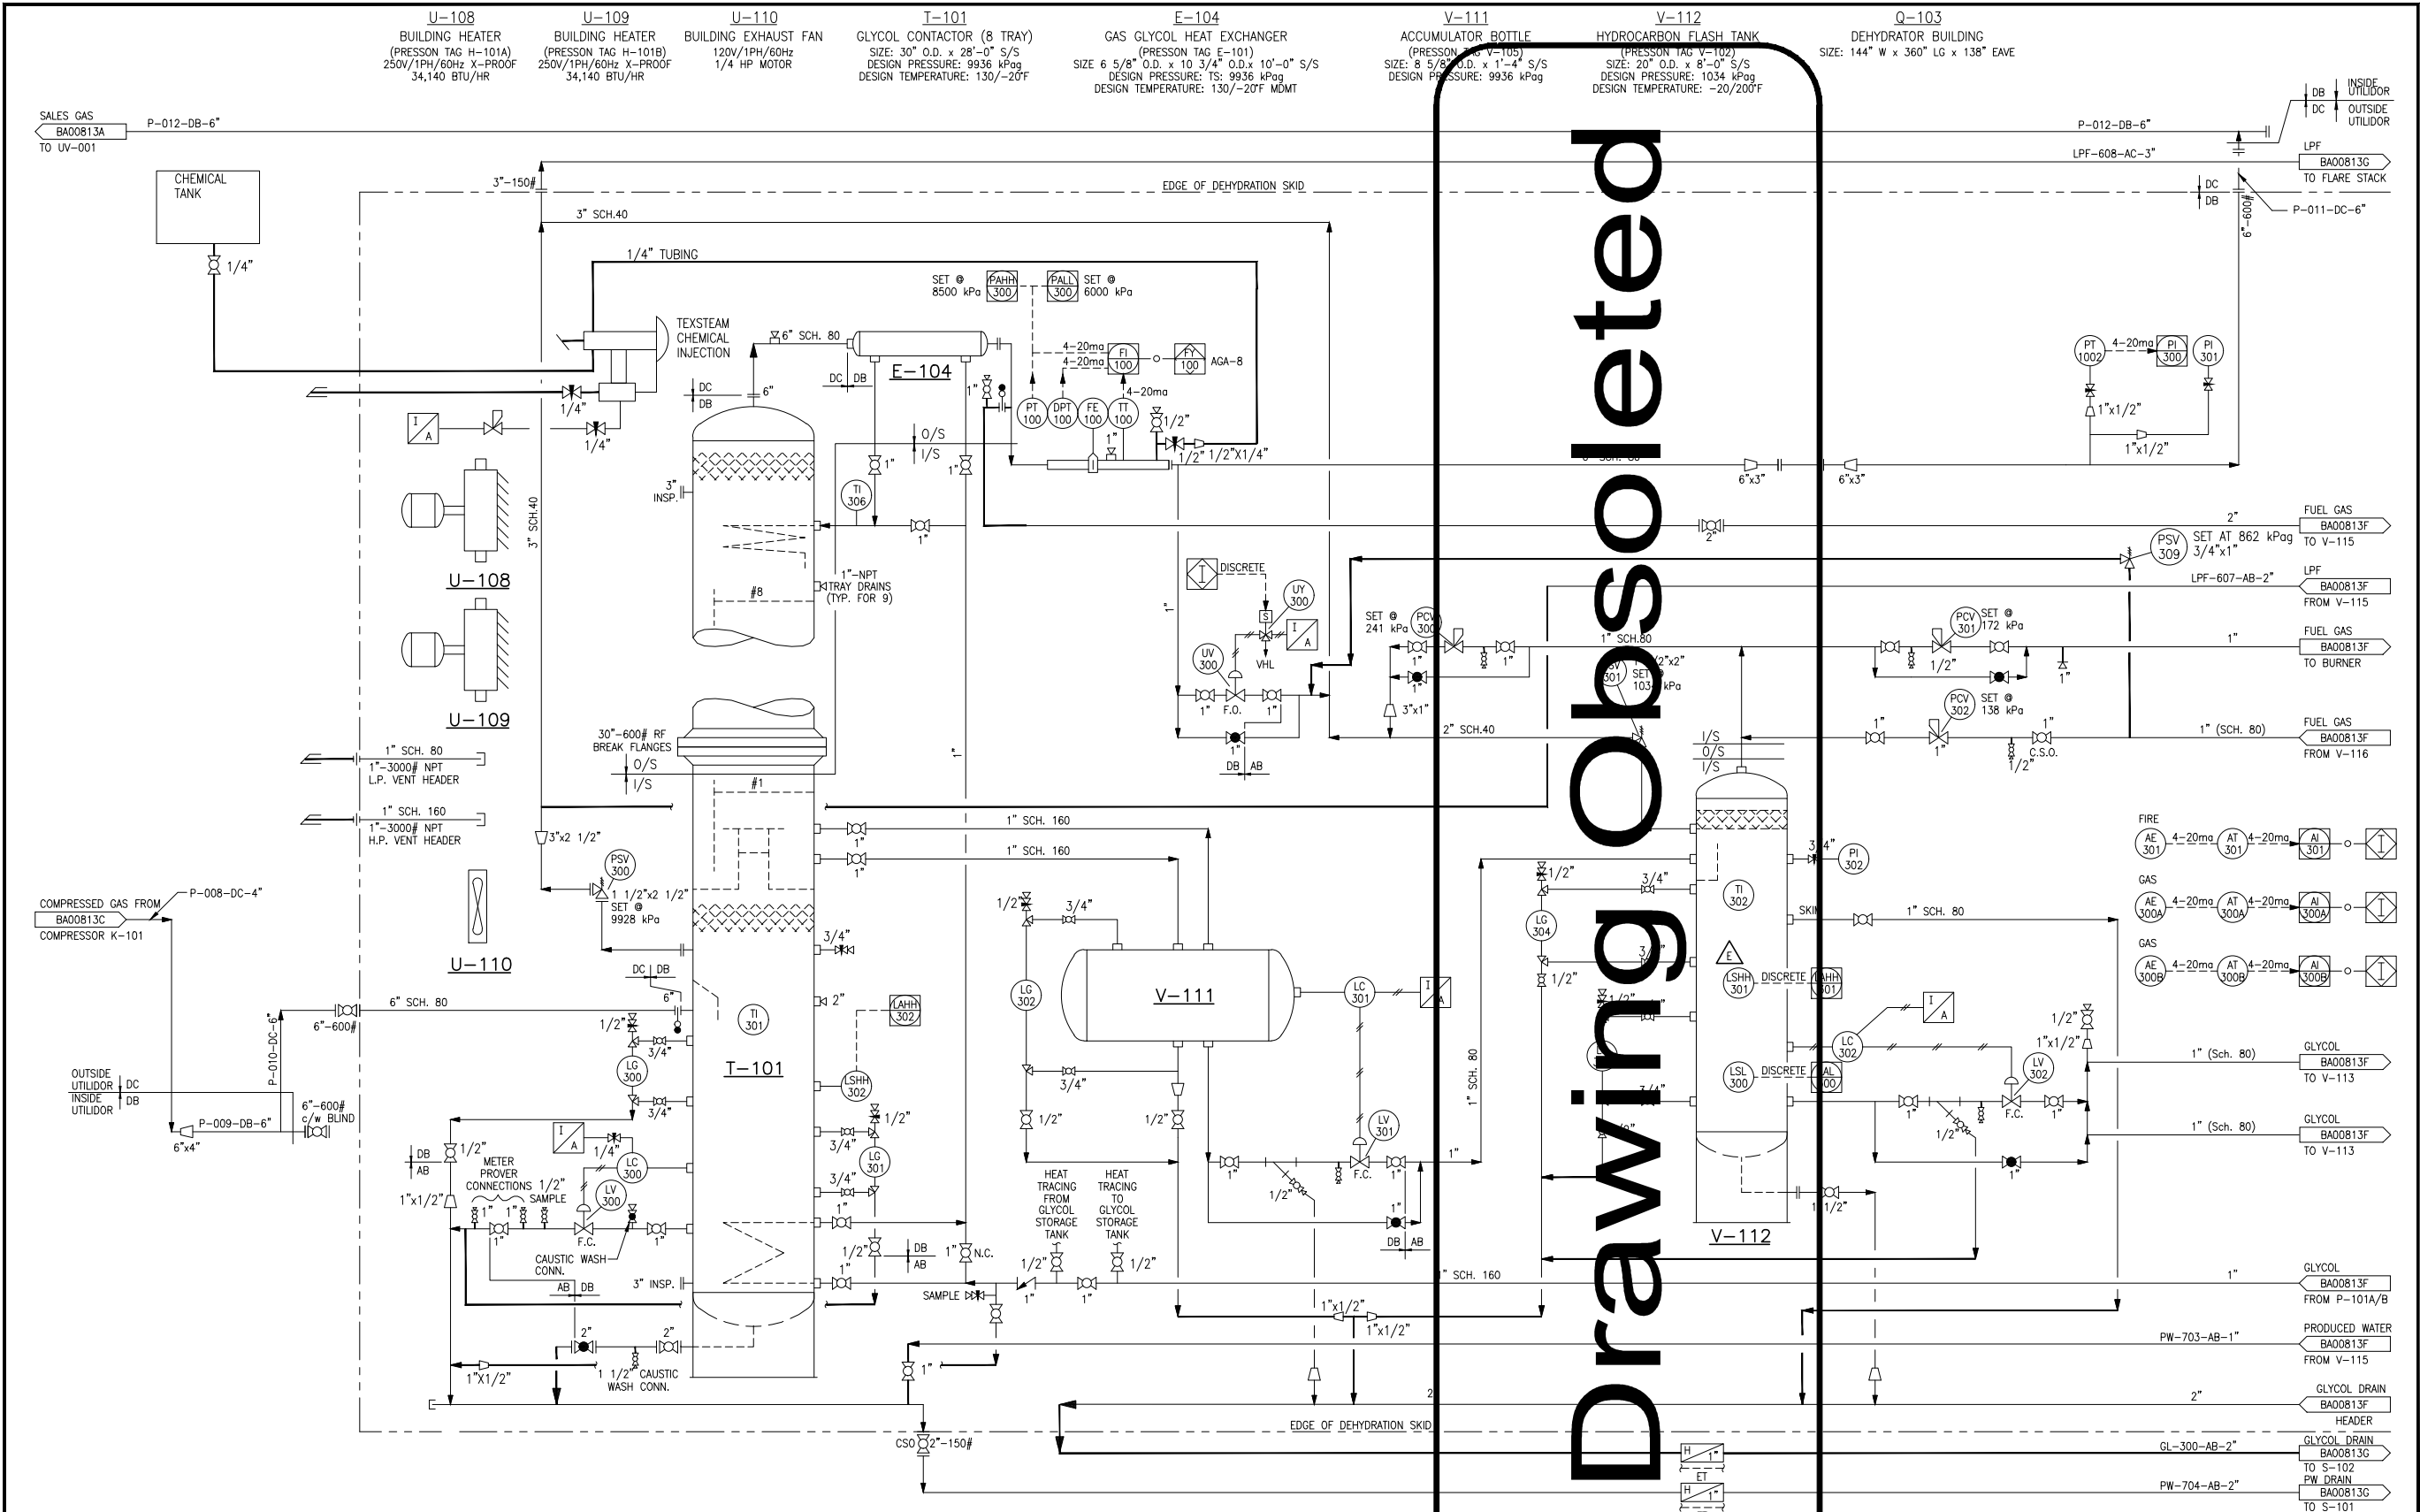

REFERENCE DRAWINGS		DWG. NO.	NO.	DATE	PROJECT DESCRIPTION	PROJ.	AFE	EPCM Co.	EPCM No.	APPD.	ISSUE STAGE		DATE	BY	CHKD.	APPD.	PERMIT STAMP		ENGINEER'S STAMP		MAIN FAC.		COMPRESSOR 03-02	
GENERAL YARD PIPING PLAN		BA00810A	0	97.06.01	COMPRESSOR STATION (AS-BUILT)	LATD001F	050J248	G.E.L.	G97068	R.T.	REV. NUMBER	OBSELETE	2025-03-11	TDH	PM	PM	TORXEN		cenovus ENERGY		03-02-022-19 W4M		COMPRESSOR 03-02	
PIPING KEY PLAN		BA00811A	1	00.12.12	BASSANO 03-02 COMPRESSOR ADDITION (AS-BUILT)	BRWD001	CM01946	GEMINI	G00-201	MDR		Bid	-	-	-	-					03-02-022-19 W4M		COMPRESSOR STATION	
PROCESS FLOW DIAGRAM		BA00812A	2	06.04.04	BASSANO WEST FACILITY DRAWING UPDATES	-	0563449	DPH	8343	-		Constr.	-	-	-	-					03-02-022-19 W4M		COMPRESSOR STATION	
		-	5	2025-03-11	OBSELETE	-	-	TORXEN	-	PM		As-built	-	-	-	-					03-02-022-19 W4M		COMPRESSOR STATION	
		-	-	-	-	-	-	-	-	-		FIELD MOD.	-	-	-	-					03-02-022-19 W4M		COMPRESSOR STATION	
		-	-	-	-	-	-	-	-	-		-	-	-	-	-					03-02-022-19 W4M		COMPRESSOR STATION	
		-	-	-	-	-	-	-	-	-		-	-	-	-	-					03-02-022-19 W4M		COMPRESSOR STATION	
		-	-	-	-	-	-	-	-	-		-	-	-	-	-					03-02-022-19 W4M		COMPRESSOR STATION	
		-	-	-	-	-	-	-	-	-		-	-	-	-	-					03-02-022-19 W4M		COMPRESSOR STATION	
		-	-	-	-	-	-	-	-	-		-	-	-	-	-					03-02-022-19 W4M		COMPRESSOR STATION	
CAUTION : READ BEFORE EXCAVATION																								
ALL EXCAVATIONS MUST BE CARRIED OUT AS PER Cenovus Energy Inc. "GROUND DISTURBANCE PRACTICES"																								