


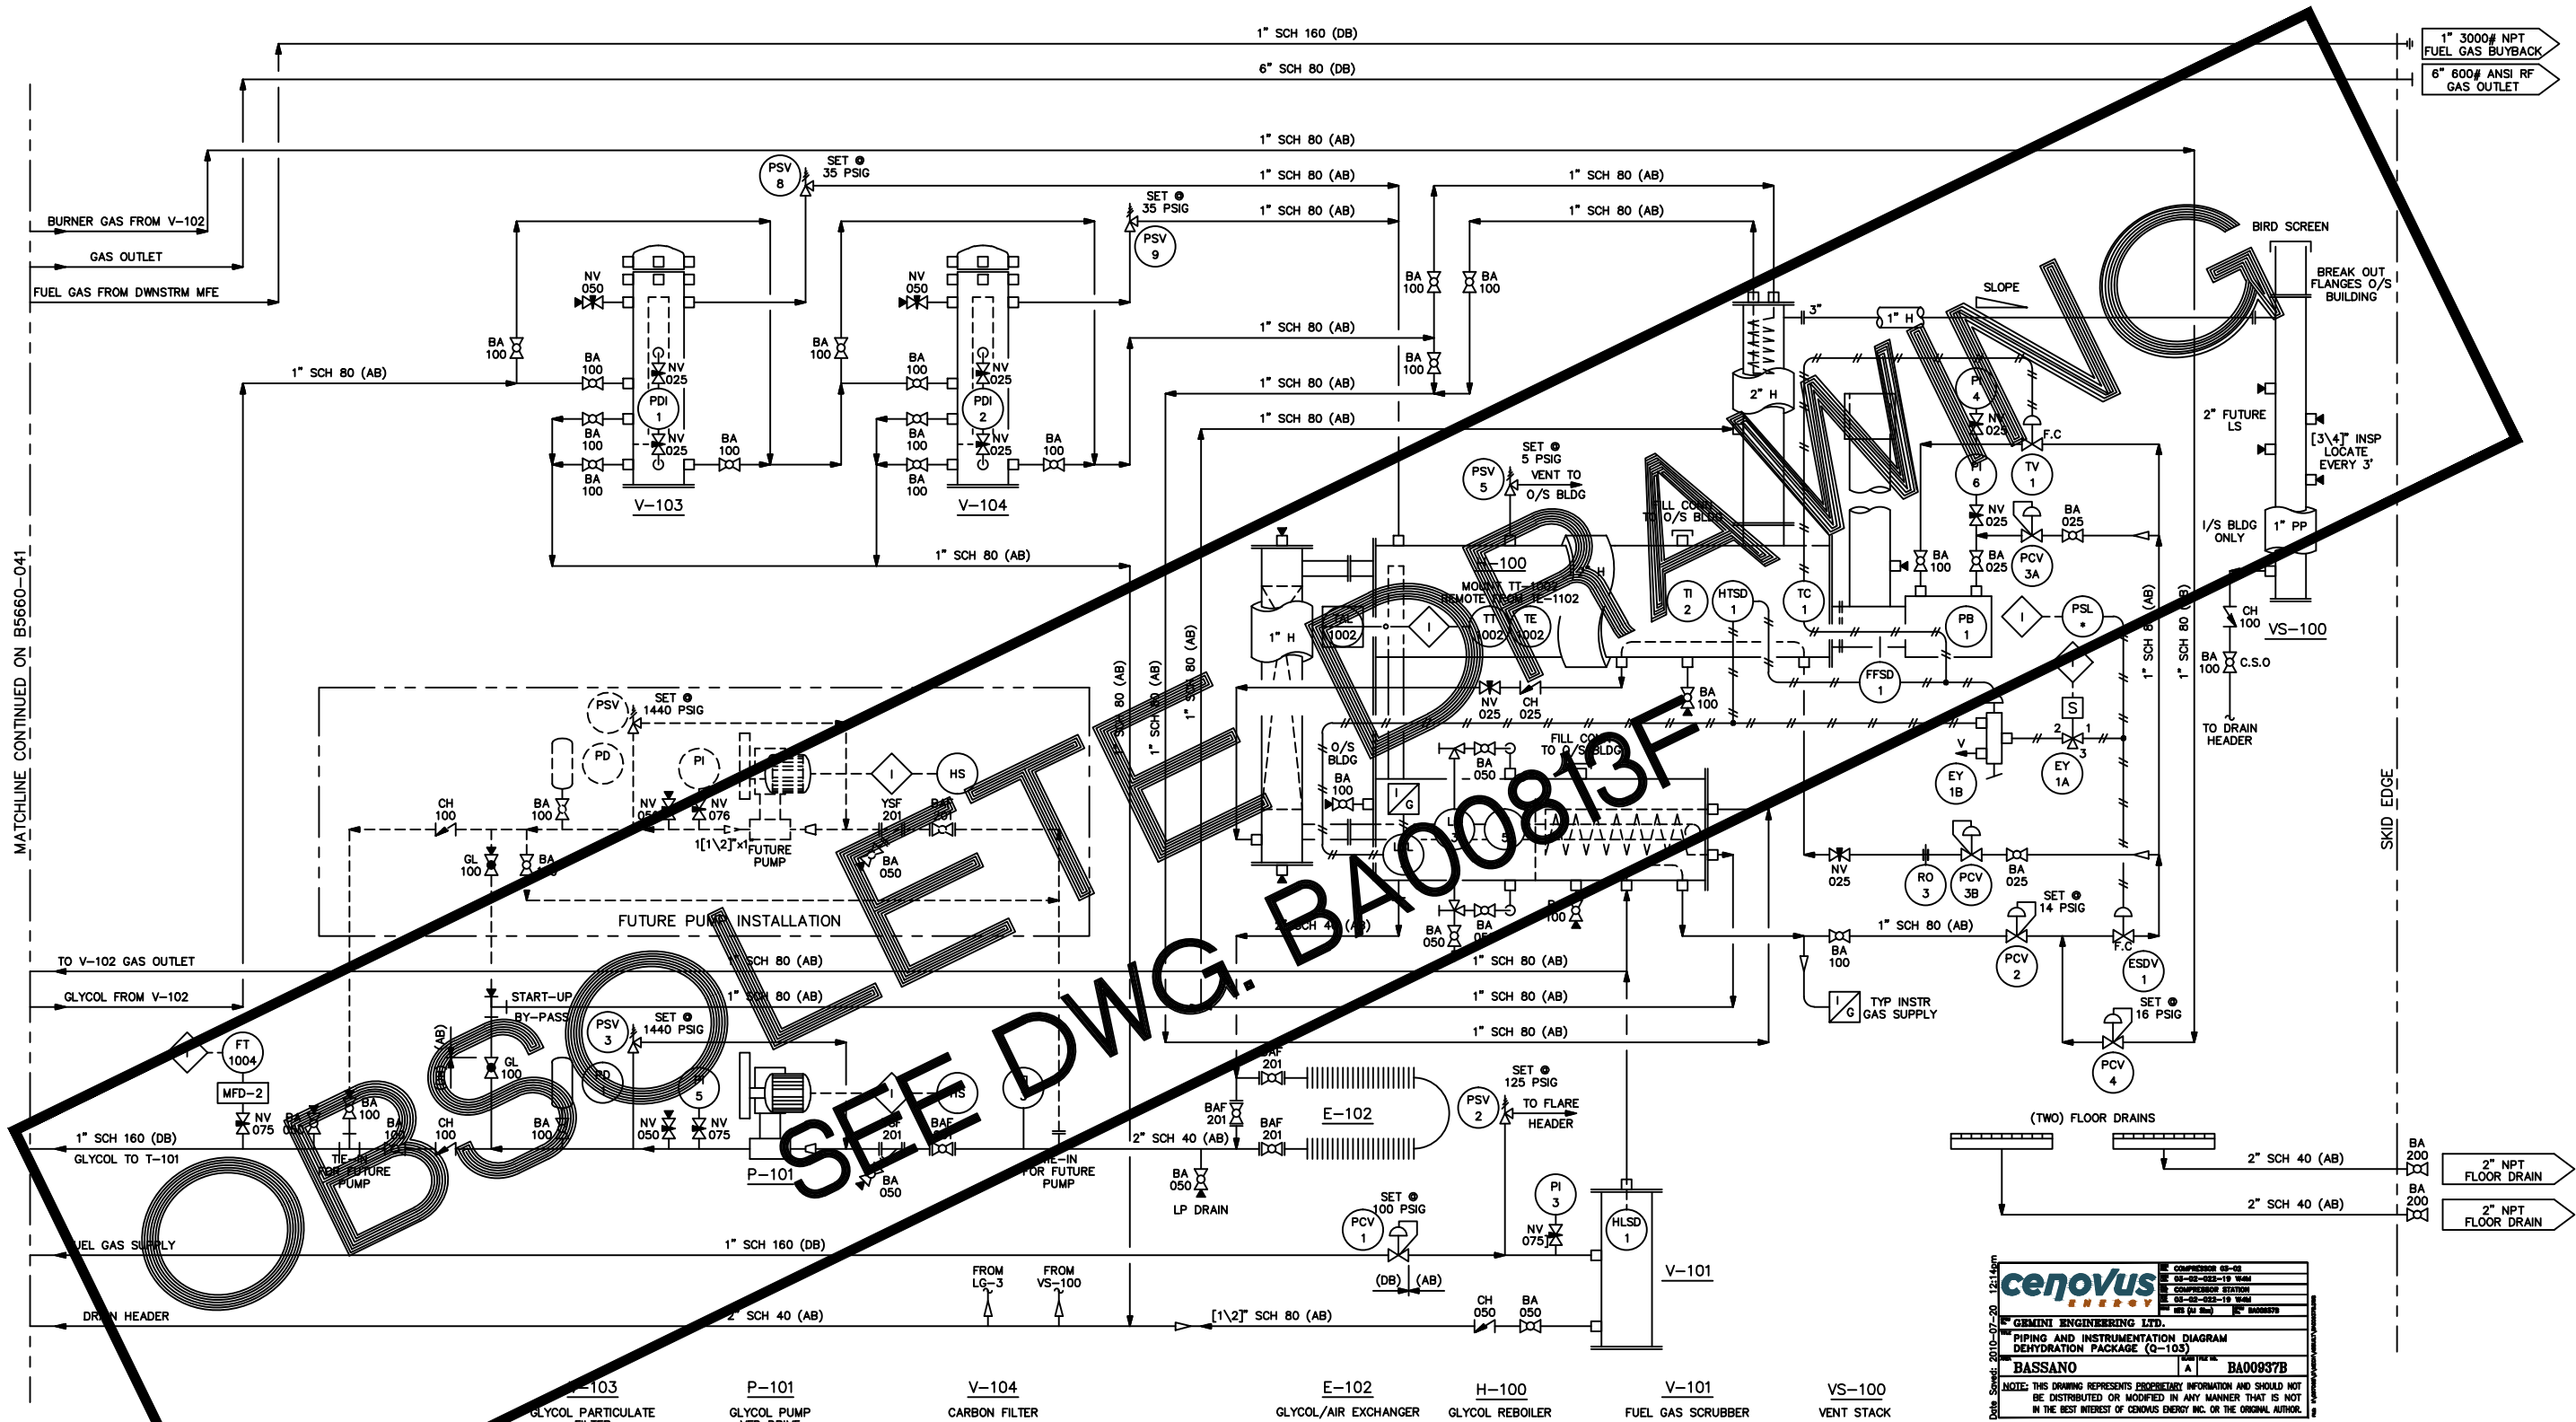

NOTES:

- 1) VHL = LOW PRESSURE VENT HEADER
- 2) VHH = HIGH PRESSURE VENT HEADER
- 3) I/G = NV-025 & FISHER 67AFR
- 4) PIPING O/S BUILDING AND UP TO FIRST WELD OR JOINT I/S BUILDING, IS TO BE OF LOW TEMP MATERIAL.

NO.	REVISION	BY	CHKD.	DATE
1	AS BUILT	LG		95/05/25
0	ISSUED FOR CONSTRUCTION	LAL		95/03/29
A	ISSUED FOR APPROVAL	LAL		95/02/21

CUSTOMER REFERENCE	2056-008
CUSTOMER	PANCANADIAN PETROLEUM LIMITED
PROJECT	30" STOCK UNITS
TITLE	GLYCOL DEHYDRATION FACILITY P & ID
DRAWN	LAL
CHECKED	
APPROVED	
SCALE	NTS
DATE	95/02/21
DRAWING NUMBER	B5660-042

PRESSON
MANUFACTURING LTD.
ENGINEERING — DESIGN — FABRICATION

cenovus
ENERGY

REVISIONS

01	COMPRESSOR 05-05
02	05-05-05-19 0401
03	COMPRESSOR 05-05
04	05-05-05-19 0401
05	05-05-05-19 0401

GENI ENGINEERING LTD.
PIPING AND INSTRUMENTATION DIAGRAM
DEHYDRATION PACKAGE (G-103)
BASSANO
BA00937B

NOTE: THIS DRAWING REPRESENTS PROPRIETARY INFORMATION AND SHOULD NOT BE DISTRIBUTED OR MODIFIED IN ANY MANNER THAT IS NOT IN THE BEST INTEREST OF GENIUS ENERGY INC. OR THE ORIGINAL AUTHOR.